

LOUIS VUITTON

114-120 GREENE STREET, NEW YORK, NY 10012

10.13.2016 - STOREFRONT WORK FOR LPC SUBMITTAL REVISION 2

AERIAL SITE PLAN	BUILDING DEPARTMENT INFORMATION	PROJECT DESCRIPTION
	<p>JURISDICTION: NEW YORK CITY</p> <p>NAME & ADDRESS: LOUIS VUITTON 114-120 GREENE STREET NEW YORK, NY 10012</p> <p>NUMBER OF STORIES: 5</p> <p>OCCUPANCY INFO: BLOCK: 499 LOT: 15 ZONING MAP: 8C DISTRICT: M1-5A: SOHO CAST-IRON</p> <p>OCCUPANCY GROUP: (C) MERCANTILE SPRINKLER: SPRINKLERED BUILDING FIRE ALARM SYSTEM: NO</p> <p>BUILDING CODE CRITERIA</p> <p>BUILDING CODE: 1968 NEW YORK BUILDING CODE WITH 2008 AMENDMENTS FIRE/LIFE SAFETY: CODES, RULES AND REGULATIONS OF THE CITY OF NY 2008 ACCESSIBILITY CODE: 2010 ADA STANDARDS FOR ACCESSIBLE DESIGN MECHANICAL CODE: NYC MECHANICAL CODE, 2014 EDITION ELECTRICAL CODE: NYC ELECTRICAL CODE, 2014 EDITION PLUMBING CODE: NYC PLUMBING CODE, 2014 EDITION ENERGY CODE: NYC ECC - ASHRAE 2010</p>	<p>114-120 GREENE STREET: THE PROPOSED SCOPE OF WORK IS TO INCLUDE THE ADDITION OF ONE BLADE SIGN.</p>

SITE PLAN	DRAWING LIST																								
	<table border="1"> <tr> <td>10.13.2016</td> <td>STOREFRONT WORK FOR LPC SUBMITTAL REVISION 2</td> <td></td> </tr> <tr> <td>09.19.2016</td> <td>STOREFRONT WORK FOR LPC SUBMITTAL REVISION</td> <td></td> </tr> <tr> <td>06.30.2016</td> <td>STOREFRONT WORK FOR LPC SUBMITTAL</td> <td></td> </tr> <tr> <td>T-001.00</td> <td>TITLE SHEET</td> <td>●●●</td> </tr> <tr> <td>A.100.00</td> <td>APPROVED AND PROPOSED ELEVATIONS</td> <td>●●●</td> </tr> <tr> <td>A.101.00</td> <td>ORIGINAL AND PROPOSED ELEVATION</td> <td>●●●</td> </tr> <tr> <td>A.102.00</td> <td>APPROVED AND PROPOSED ELEVATION IMAGES</td> <td>●●●</td> </tr> <tr> <td>A.103.00</td> <td>EXTERIOR SIGNAGE DETAILS</td> <td>●●●</td> </tr> </table>	10.13.2016	STOREFRONT WORK FOR LPC SUBMITTAL REVISION 2		09.19.2016	STOREFRONT WORK FOR LPC SUBMITTAL REVISION		06.30.2016	STOREFRONT WORK FOR LPC SUBMITTAL		T-001.00	TITLE SHEET	●●●	A.100.00	APPROVED AND PROPOSED ELEVATIONS	●●●	A.101.00	ORIGINAL AND PROPOSED ELEVATION	●●●	A.102.00	APPROVED AND PROPOSED ELEVATION IMAGES	●●●	A.103.00	EXTERIOR SIGNAGE DETAILS	●●●
10.13.2016	STOREFRONT WORK FOR LPC SUBMITTAL REVISION 2																								
09.19.2016	STOREFRONT WORK FOR LPC SUBMITTAL REVISION																								
06.30.2016	STOREFRONT WORK FOR LPC SUBMITTAL																								
T-001.00	TITLE SHEET	●●●																							
A.100.00	APPROVED AND PROPOSED ELEVATIONS	●●●																							
A.101.00	ORIGINAL AND PROPOSED ELEVATION	●●●																							
A.102.00	APPROVED AND PROPOSED ELEVATION IMAGES	●●●																							
A.103.00	EXTERIOR SIGNAGE DETAILS	●●●																							

PROJECT DIRECTORY

BUILDING LANDLORD	TENANT:	ARCHITECT:	EXPEDITOR
<p>7 COMPTON DRIVE EAST WINDSOR, NJ 08502</p> <p>CONTACT: ROBERT HOLLAND PH: 609.865.0470 FX: 212.931.2737 robert_d_holland@msn.com</p>	<p>LOUIS VUITTON NA, INC. 1 EAST 57TH STREET 12TH FL NEW YORK, NY 10022 CONTACT: LANDIS KAUFFMAN PH: 917.281.2189 FX: l.kauffman@us.vuitton.com</p>	<p>CALLISON ARCHITECTS, PC 148 LAFAYETTE STREET 11TH FL NEW YORK, NY 10013 CONTACT: STERLING PLENERT PH: 646.747.0877 sterling.plenert@callison.com</p> <p>SIGNING ARCHITECT: LEE HAGEN</p>	<p>OUTSOURCE CONSULTANTS, INC. 1237 WEST 35TH STREET, FLOOR 12A NEW YORK, NY 10001 CONTACT: ANGIE SILVA PH: 212.732.0555 FX: EMAIL: asilva@OutsourceConsultants.com</p>

TENANT:
LOUIS VUITTON NA, INC.
1 EAST 57TH STREET 12TH FL
NEW YORK, NY 10022
CONTACT: LANDIS KAUFFMAN
PH: 917.281.2189
FX:
l.kauffman@us.vuitton.com

MEP ENGINEER:

STRUCTURAL ENGINEER:

CALLISON
www.callison.com

LOUIS VUITTON
114-120 GREENE STREET
NEW YORK, NY 10012
PROJECT #003-140817.01

NEW YORK CITY ENERGY CODE:
TO THE BEST OF MY KNOWLEDGE, BELIEF AND
PROFESSIONAL JUDGMENT, THESE PLANS AND
SPECIFICATIONS ARE IN COMPLIANCE WITH THE NEW
YORK CITY ENERGY CONSERVATION CODE.


NEW YORK CITY BUILDING DEPARTMENT APPROVAL NOTE:
THESE PLANS ARE APPROVED ONLY FOR WORK NOTICED ON
THE APPLICATION SPECIFICATION SHEET. ALL OTHER
MATTERS SHOWN ARE NOT TO BE RELIED UPON OR TO BE
CONSIDERED AS EITHER BEING APPROVED OR IN
ACCORDANCE WITH APPLICABLE CODES.

IT IS A VIOLATION OF LAW FOR ANY PERSON UNLESS
THEY ARE ACTING UNDER THE DIRECTION OF A
LICENSED PROFESSIONAL ARCHITECT, TO ALTER AN
ITEM IN ANY WAY ON THE DRAWING OR
SPECIFICATION DOCUMENT. IF A DOCUMENT
BEARING THE SEAL OF AN ARCHITECT IS ALTERED
THE ALTERING ARCHITECT SHALL AFFIX TO THE
DOCUMENT THEIR SEAL AND THE NOTIFICATION
ALTERED BY FOLLOWED BY THEIR SIGNATURE AND
THE DATE OF SUCH ALTERATION AND A SPECIFIC
DESCRIPTION OF THE ALTERATION.


ISSUED / REVISED	REV.	DATE
LANDMARKS		06/29/2015
DOB		11/16/2015
LANDMARKS	1	03/21/2016
LANDMARKS	2	04/07/2016
LANDMARKS	3	04/28/2016
DOB		05/09/2016
LPC		07/01/2016
LPC REV.1		09/19/2016
LPC REV.2		10/13/2016

TITLE SHEET

T-001.00
SHEET # 01 OF 05

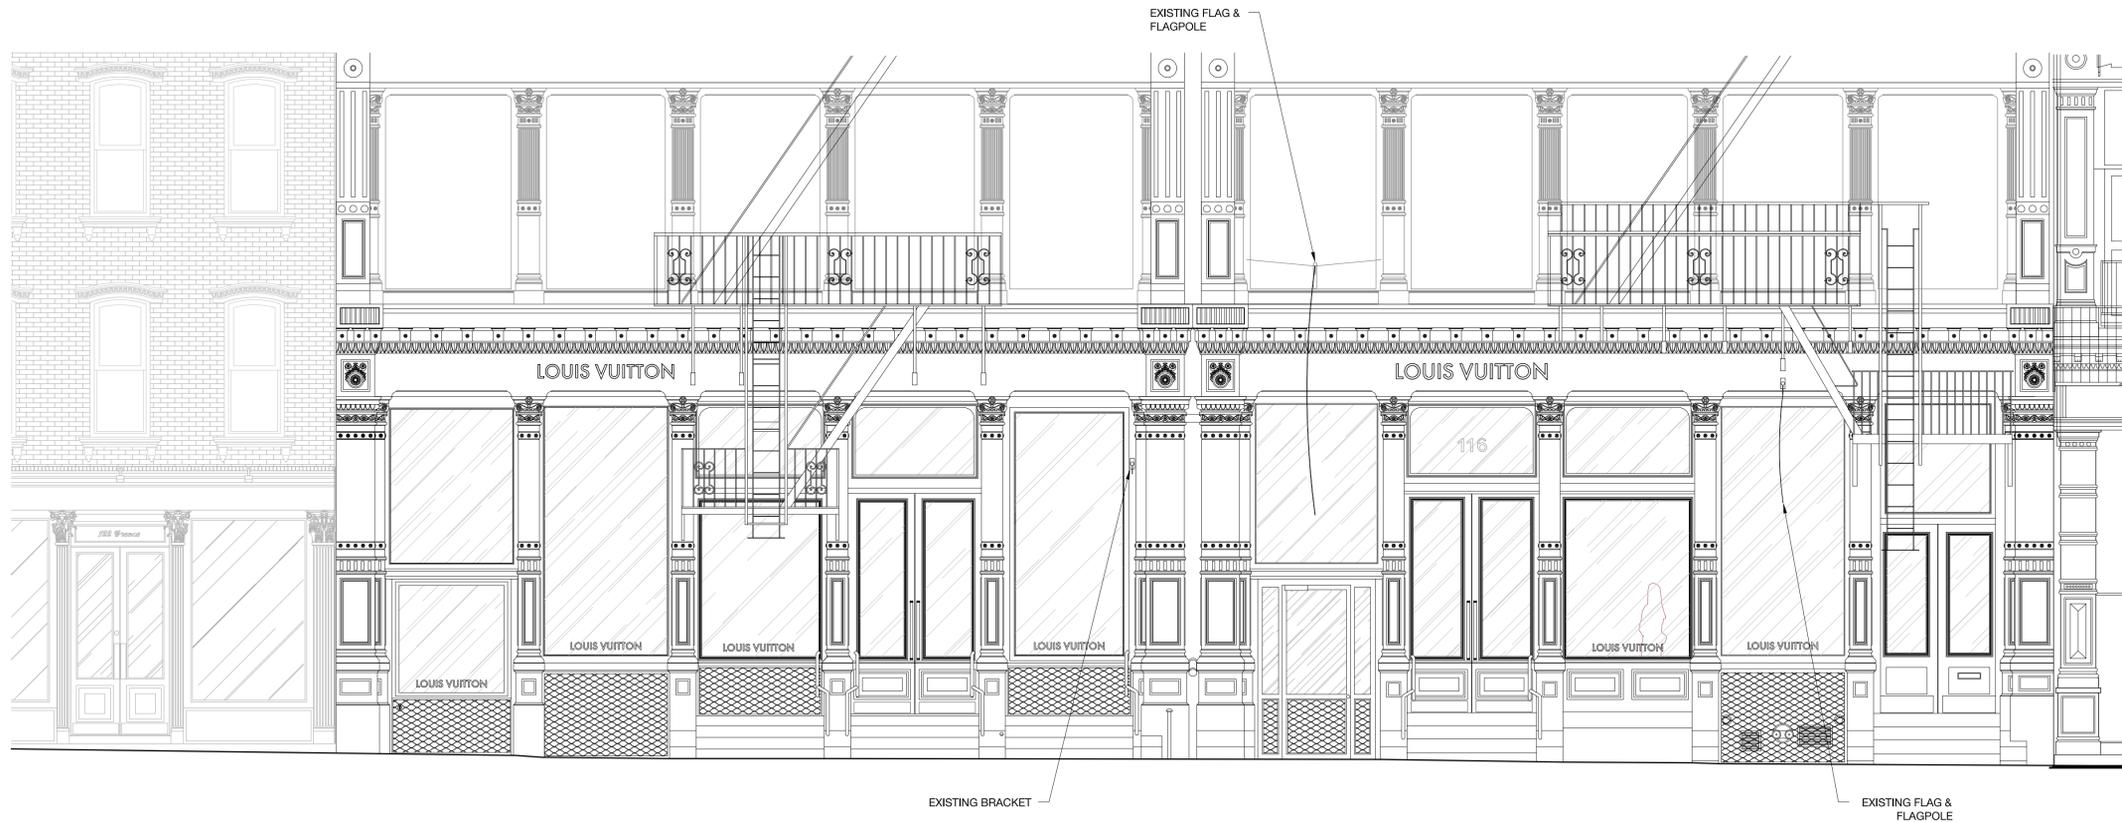

1 GREENE STREET
APPROVED ELEVATION
 SCALE: 1/4" = 1'-0"

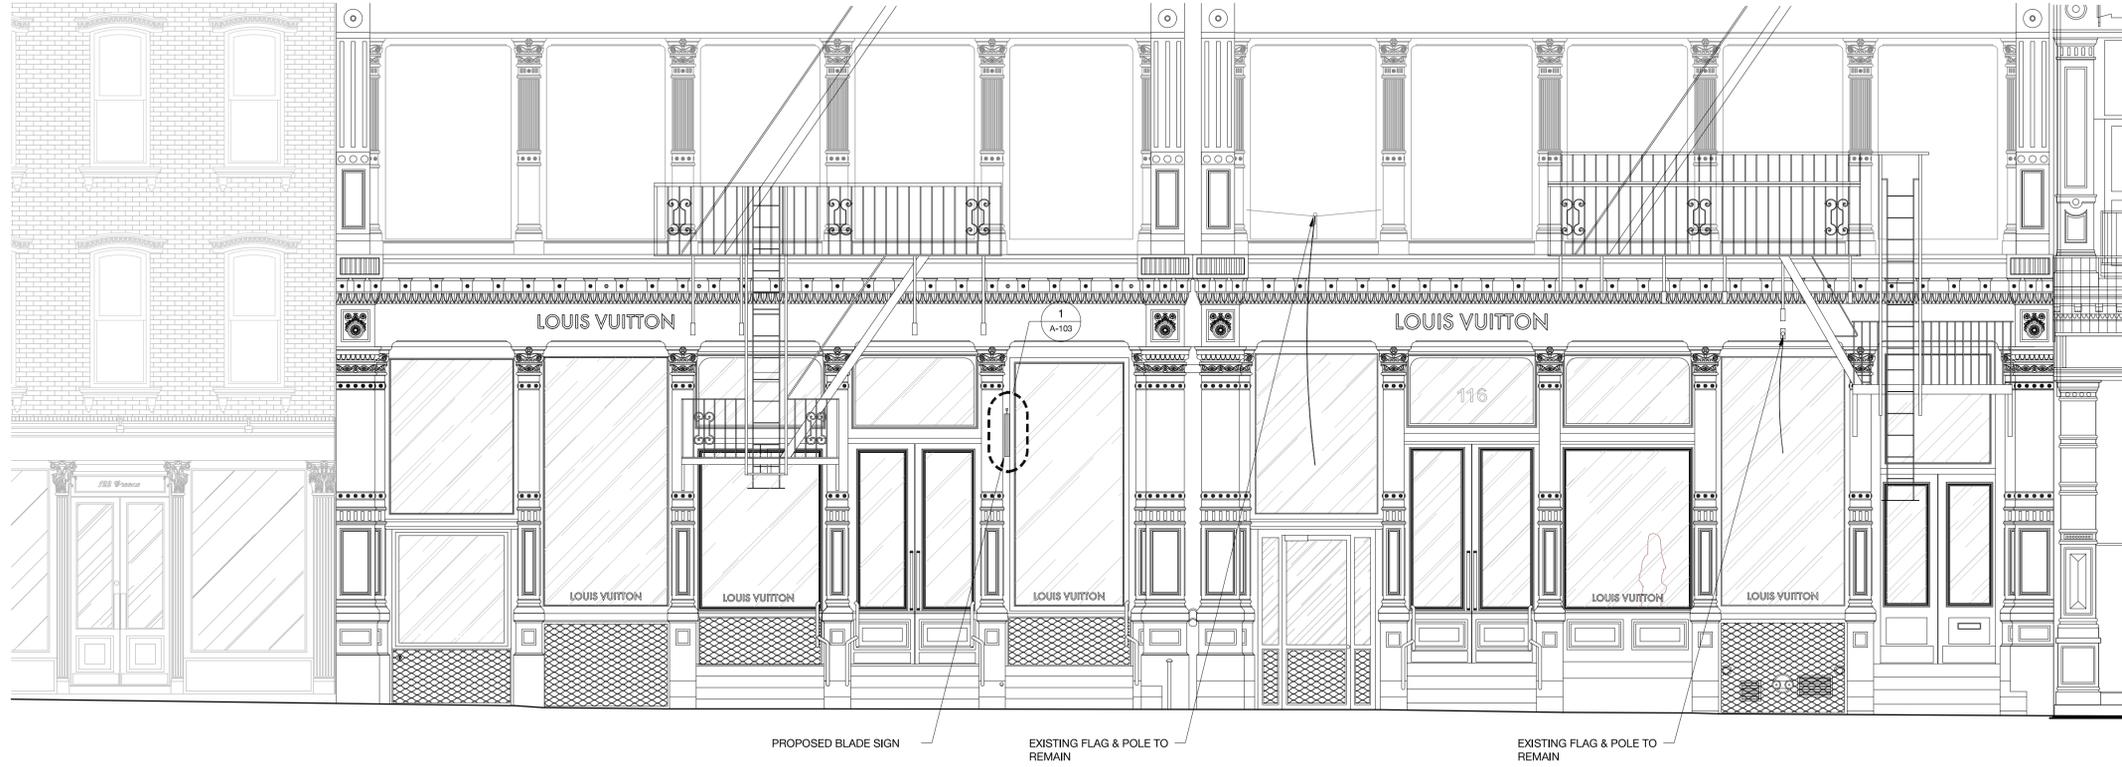

2 GREENE STREET
PROPOSED ELEVATION
 SCALE: 1/4" = 1'-0"

SCOPE AND NOTES

ADDITION OF ONE BLADE SIGN ON GROUND FLOOR FACADE AT 114-120 GREENE STREET IN SOHO CAST IRON DISTRICT.

- NEW 'LV' BLADE SIGN TO BE ADDED AT STOREFRONT OF 118-120 GREENE STREET. SEE SHEET A-103.00 FOR DETAILS

APPROVED ELEVATION:
 -TWO FLAGS & FLAGPOLES
 -ONE GRANDFATHERED BRACKET

PROPOSED ELEVATION:
 -TWO FLAGS & FLAGPOLES
 -ONE BLADE SIGN

TENANT:
 LOUIS VUITTON NA, INC.
 1 EAST 57TH STREET 12TH FL
 NEW YORK, NY 10022
 CONTACT: LANDIS KAUFFMAN
 P: 817.261.2189
 Lkauffman@us.louisvuitton.com

MEP ENGINEER:

STRUCTURAL ENGINEER:

CALLISON
 www.callison.com

LOUIS VUITTON
 114-120 GREENE STREET
 NEW YORK, NY 10012
 PROJECT #003-140817.01

NEW YORK CITY ENERGY CODE TO THE BEST OF MY KNOWLEDGE, BELIEF AND PROFESSIONAL JUDGMENT, THESE PLANS AND SPECIFICATIONS ARE IN COMPLIANCE WITH THE NEW YORK CITY ENERGY CONSERVATION CODE.

NEW YORK CITY BUILDING DEPARTMENT APPROVAL NOTE: THESE PLANS APPROVED ONLY FOR WORK REQUESTED ON THE APPLICATION SPECIFICATION SHEET. ALL OTHER MATTERS SHOWN ARE NOT TO BE RELIED UPON OR TO BE CONSIDERED AS EITHER BEING APPROVED OR IN ACCORDANCE WITH APPLICABLE CODES.


IT IS A VIOLATION OF LAW FOR ANY PERSON UNLESS THEY ARE ACTING UNDER THE DIRECTION OF A LICENSED PROFESSIONAL ARCHITECT, TO ALTER AN ITEM IN ANY WAY ON THE DRAWING OR SPECIFICATION DOCUMENT. IF A DOCUMENT BEARING THE SEAL OF AN ARCHITECT IS ALTERED THE ALTERING ARCHITECT SHALL AFFIX TO THE DOCUMENT THEIR SEAL AND THE NOTIFICATION "ALTERED BY" FOLLOWED BY THEIR SIGNATURE AND THE DATE OF SUCH ALTERATION AND A SPECIFIC DESCRIPTION OF THE ALTERATION.

ISSUED / REVISED	REV. DATE
LANDMARKS	06/29/2015
DOB	11/16/2015
LANDMARKS	1 03/21/2016
LANDMARKS	2 04/07/2016
LANDMARKS	3 04/28/2016
DOB	05/09/2016
LPC	07/01/2016
LPC REV.1	09/19/2016
LPC REV.2	10/13/2016


APPROVED AND PROPOSED ELEVATIONS

A-100.00

SHEET # 02 OF 05

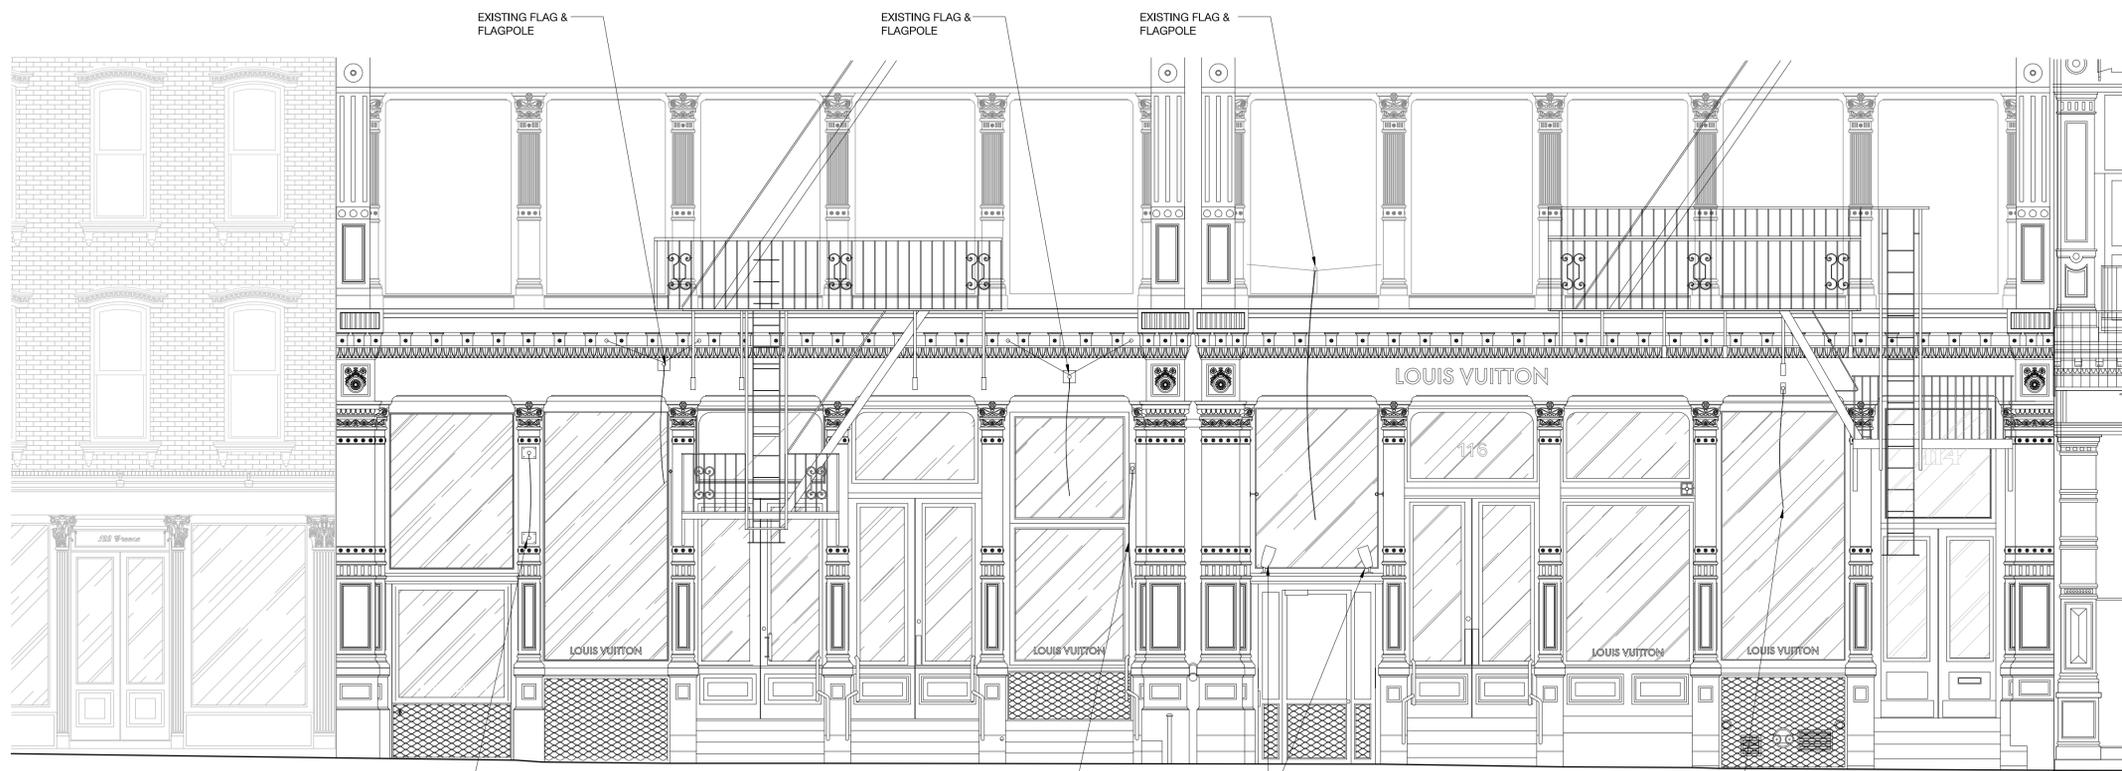

1 GREENE STREET
2015 ELEVATION
 SCALE: 1/4" = 1'-0"

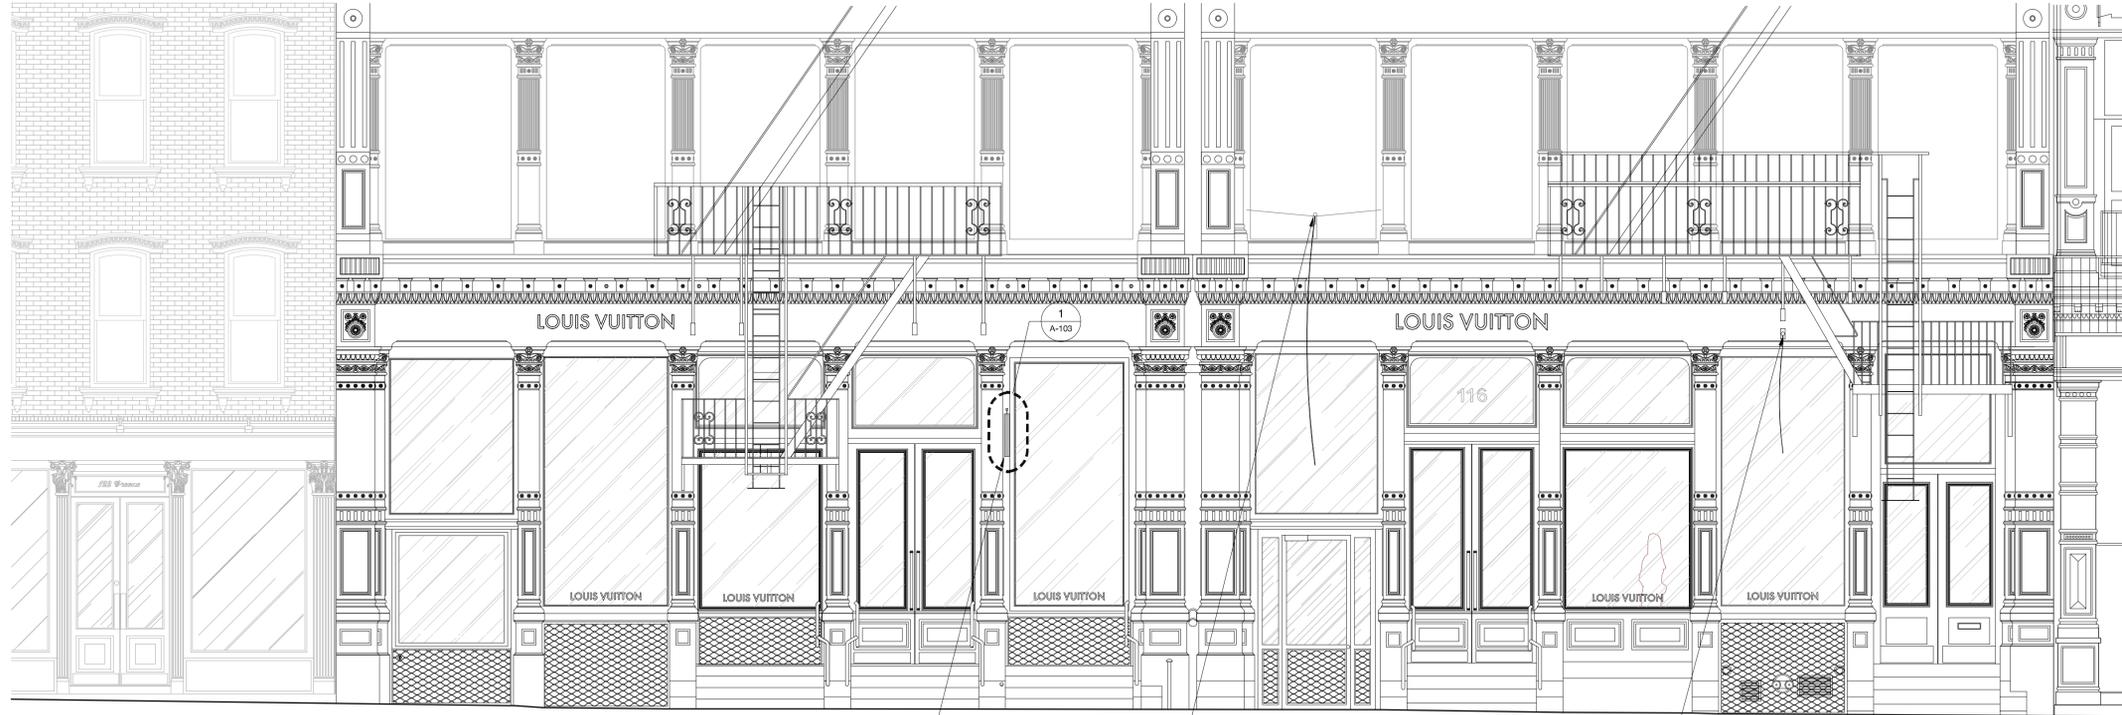

2 GREENE STREET
PROPOSED ELEVATION
 SCALE: 1/4" = 1'-0"

SCOPE AND NOTES

ADDITION OF ONE BLADE SIGN ON GROUND FLOOR FACADE AT 114-120 GREENE STREET IN SOHO CAST IRON DISTRICT.

- NEW 'LV' BLADE SIGN TO BE ADDED AT STOREFRONT OF 118-120 GREENE STREET. SEE SHEET A-103.00 FOR DETAILS

APPROVED ELEVATION:
 -TWO FLAGS & FLAGPOLES
 -ONE GRANDFATHERED BRACKET

PROPOSED ELEVATION:
 -TWO FLAGS & FLAGPOLES
 -ONE BLADE SIGN

TENANT:
 LOUIS VUITTON NA, INC.
 1 EAST 57TH STREET 12TH FL
 NEW YORK, NY 10022
 CONTACT: LANDIS KAUFFMAN
 P: 817.261.2189
 Lkauffman@louisvuitton.com

MEP ENGINEER:

STRUCTURAL ENGINEER:

CALLISON
 www.callison.com

LOUIS VUITTON
 114-120 GREENE STREET
 NEW YORK, NY 10012
 PROJECT #003-140817.01

NEW YORK CITY ENERGY CODE TO THE BEST OF MY KNOWLEDGE, BELIEF AND PROFESSIONAL JUDGMENT, THESE PLANS AND SPECIFICATIONS ARE IN COMPLIANCE WITH THE NEW YORK CITY ENERGY CONSERVATION CODE.

NEW YORK CITY BUILDING DEPARTMENT APPROVAL NOTE: THESE PLANS APPROVED ONLY FOR WORK REQUIRED BY THE APPLICATION SPECIFICATION SHEET. ALL OTHER MATTERS SHOWN ARE NOT TO BE RELIED UPON OR TO BE CONSIDERED AS EITHER BEING APPROVED OR IN ACCORDANCE WITH APPLICABLE CODES.

IT IS A VIOLATION OF LAW FOR ANY PERSON UNLESS THEY ARE ACTING UNDER THE DIRECTION OF A LICENSED PROFESSIONAL ARCHITECT, TO ALTER AN ITEM IN ANY WAY ON THE DRAWING OR SPECIFICATION DOCUMENT. IF A DOCUMENT BEARING THE SEAL OF AN ARCHITECT IS ALTERED THE ALTERING ARCHITECT SHALL AFFIX TO THE DOCUMENT THEIR SEAL AND THE NOTIFICATION "ALTERED BY" FOLLOWED BY THEIR SIGNATURE AND THE DATE OF SUCH ALTERATION AND A SPECIFIC DESCRIPTION OF THE ALTERATION.

ISSUED / REVISED	REV. DATE
LANDMARKS	06/29/2015
DOB	11/16/2015
LANDMARKS	1 03/21/2016
LANDMARKS	2 04/07/2016
LANDMARKS	3 04/28/2016
DOB	05/09/2016
LPC	07/01/2016
LPC REV.1	09/19/2016
LPC REV.2	10/13/2016

ORIGINAL AND PROPOSED ELEVATIONS

A-101.00

SHEET # 03 OF 05



1 APPROVED ELEVATION
SCALE: NTS



2 PROPOSED ELEVATION
SCALE: NTS

PROPOSED BLADE SIGN

TENANT:
LOUIS VUITTON NA, INC.
1 EAST 57TH STREET 12TH FL
NEW YORK, NY 10022
CONTACT: LANDIS KAUFFMAN
P: 817.261.2189
l.kauffman@us.louisvuitton.com

MEP ENGINEER:

STRUCTURAL ENGINEER:

CALLISON

www.callison.com

LOUIS VUITTON

114-120 GREENE STREET
NEW YORK, NY 10012

PROJECT #003-140817.01

NEW YORK CITY ENERGY CODE:
TO THE BEST OF MY KNOWLEDGE, BELIEF AND
PROFESSIONAL JUDGMENT, THESE PLANS AND
SPECIFICATIONS ARE IN COMPLIANCE WITH THE NEW
YORK CITY ENERGY CONSERVATION CODE.

NEW YORK CITY BUILDING DEPARTMENT APPROVAL NOTE:
THE PLANS APPROVED ONLY FOR WORK NOTICED ON:
THE APPLICATION SPECIFICATION SHEET. ALL OTHER
MATTERS SHOWN ARE NOT TO BE RELIED UPON OR TO BE
CONSIDERED AS EITHER BEING APPROVED OR IN
ACCORDANCE WITH APPLICABLE CODES.




IT IS A VIOLATION OF LAW FOR ANY PERSON UNLESS
THEY ARE ACTING UNDER THE DIRECTION OF A
LICENSED PROFESSIONAL ARCHITECT, TO ALTER AN
ITEM IN ANY WAY ON THE DRAWING OR
SPECIFICATION DOCUMENT. IF A DOCUMENT
BEARING THE SEAL OF AN ARCHITECT IS ALTERED
THE ALTERING ARCHITECT SHALL AFFIX TO THE
DOCUMENT THEIR SEAL AND THE NOTIFICATION:
"ALTERED BY" FOLLOWED BY THEIR SIGNATURE AND
THE DATE OF SUCH ALTERATION AND A SPECIFIC
DESCRIPTION OF THE ALTERATION.

ISSUED / REVISED	REV.	DATE
LANDMARKS		06/29/2015
DOB		11/16/2015
LANDMARKS	1	03/21/2016
LANDMARKS	2	04/07/2016
LANDMARKS	3	04/28/2016
DOB		05/09/2016
LPC		07/01/2016
LPC REV.1		09/19/2016
LPC REV.2		10/13/2016

APPROVED AND PROPOSED
ELEVATIONS IMAGES

A-102.00

SHEET # 04 OF 05

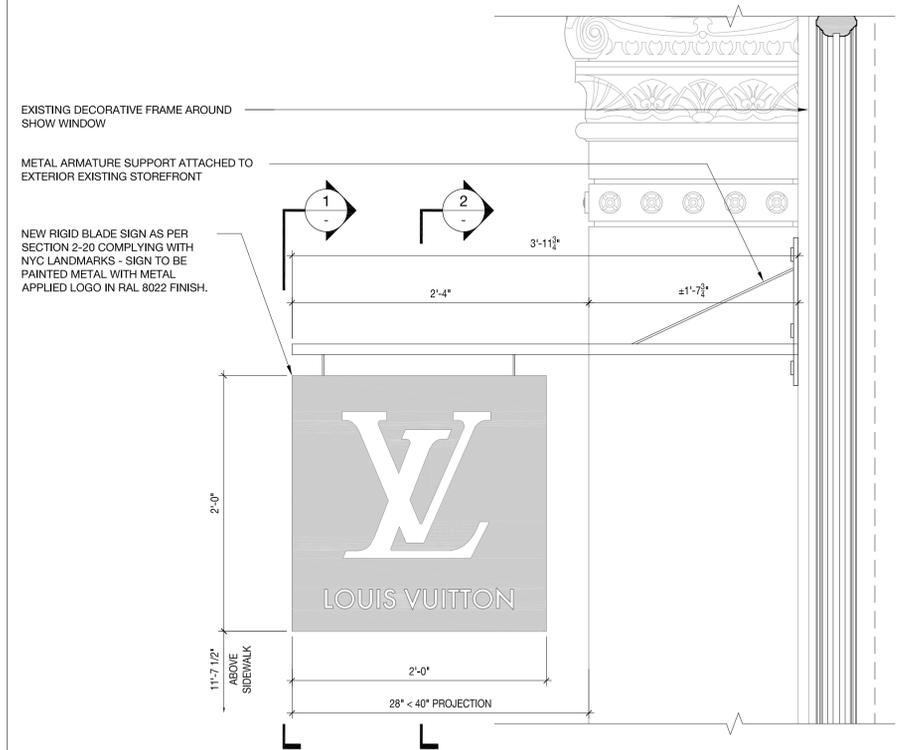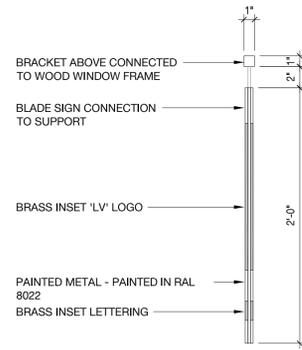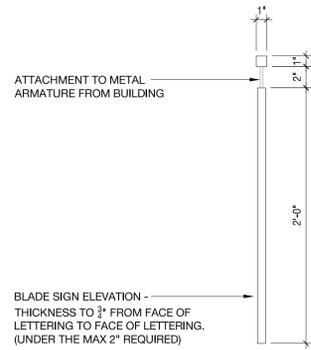

1 NEW HANGING METAL SIGNAGE ON GREENE STREET
ELEVATION
SCALE: 1-1/2" = 1'-0"

2 NEW HANGING METAL SIGNAGE ON GREENE STREET
SECTION
SCALE: 1-1/2" = 1'-0"

3 NEW HANGING METAL SIGNAGE ON GREENE STREET
ELEVATION
SCALE: 1-1/2" = 1'-0"

NOTE: PROPOSED BLADE SIGN IS ATTACHED TO FLAT PORTION OF WINDOW. NO CONNECTION TO CAST IRON.

TENANT:
LOUIS VUITTON NA, INC.
1 EAST 57TH STREET 12TH FL
NEW YORK, NY 10022
CONTACT: LANDIS KAUFFMAN
P: 917.281.2189
F: lkauffman@louisvuitton.com

MEP ENGINEER:

STRUCTURAL ENGINEER:

CALLISON
www.callison.com

LOUIS VUITTON
114-120 GREENE STREET
NEW YORK, NY 10012
PROJECT #003-140817.01

NEW YORK CITY ENERGY CODE:
TO THE BEST OF MY KNOWLEDGE, BELIEF AND PROFESSIONAL JUDGEMENT, THESE PLANS AND SPECIFICATIONS ARE IN COMPLIANCE WITH THE NEW YORK CITY ENERGY CONSERVATION CODE.
NEW YORK CITY BUILDING DEPARTMENT APPROVAL NOTE:
THE PLANS APPROVED ON 1/16/2015 FOR WORK NOTICED ON THE APPLICATION SPECIFICATION SHEET. ALL OTHER MATTERS SHOWN ARE NOT TO BE RELIED UPON OR TO BE CONSIDERED AS EITHER BEING APPROVED OR IN ACCORDANCE WITH APPLICABLE CODES.
IT IS A VIOLATION OF LAW FOR ANY PERSON UNLESS THEY ARE ACTING UNDER THE DIRECTION OF A LICENSED PROFESSIONAL ARCHITECT, TO ALTER AN ITEM IN ANY WAY ON THIS DRAWING OR SPECIFICATION DOCUMENT. IF A DOCUMENT BEARING THE SEAL OF AN ARCHITECT IS ALTERED, THE ALTERING ARCHITECT SHALL AFFIX TO THE DOCUMENT THEIR SEAL AND THE NOTIFICATION "ALTERED BY" FOLLOWED BY THEIR SIGNATURE AND THE DATE OF SUCH ALTERATION AND A SPECIFIC DESCRIPTION OF THE ALTERATION.

ISSUED / REVISED	REV.	DATE
LANDMARKS	06/29/2015	
DOB	11/16/2015	
LANDMARKS	1	03/21/2016
LANDMARKS	2	04/07/2016
LANDMARKS	3	04/28/2016
DOB	05/09/2016	
LPC	07/01/2016	
LPC REV.1	09/19/2016	
LPC REV.2	10/13/2016	

EXTERIOR SIGNAGE DETAILS

A-103.00

SHEET # 05 OF 05